

© □ ¤ ⊠ ⊠

ALARM STROBE

FIRE ALARM HORN / STROBE COMBINATION

ALARM

FIRE ALARM HORN

PHOTOELECTRIC

SMOKE DETECTOR, ADDRESSABLE

FIRE

ALARM RISER

ST S

FIRE ALARM TAMPER SWITCH

CONTROL RELAY

FIRE ALARM CONTROL PANEL. ADDRESSABLE

S

⊙ ≰

HEAT DETECTOR,

FIXED TEMPERATURE (135°).


ALARM FLOW SWITCH

8

PHOTOELECTRIC SMOKE ALARM AND CARBON MONOXIDE COMBO, ADDRESSABLE

8

DUCT SMOKE DETECTOR, ADDRESSABLE,

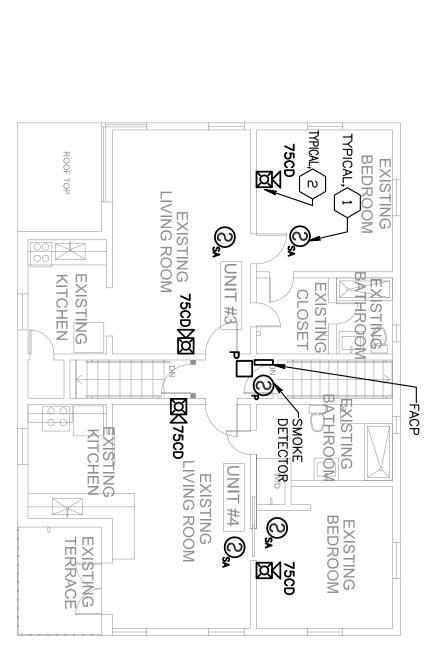



WESLEY ART CASTELLAI FLORIDA ARCHITECT LICENSE PROJECT NO: 2014-32 FIRE ALARM PLAN CHECKED BY: A.R. CHECKED BY: A.R. DRAWN BY: A.R. SCALE: AS NOTED SCALE: AS NOTED OTHER CASTELLAI WESLEY ART CASTELLAI FLORIDA FIRE ARM PLAN SHEET NO:		JOB # 15-0902 Amarilis Rodriguez, P.E. License Number 60236 C.A. 26359 Signature Date	engineering inc onal Plaza toad, Suite 1109 Engineering Design: orida 33134 Mechanical > Electrical Mechanical > Fire Protection 9809 Plumbing > Fire Protection	enginee Plaza Plaza pad, Suite 1109 rida 33134 9809	1/8" = 1'-0" 1/8" = 1'-0" Coral Gables, Florida 33134 Phone > 305 444 9809	SCALE:
	> 	R PLAI	FIRE ALARM SECOND FLOOR PLAN	SECC	ALARM	FIRE
	: •);;;j			

STING ROOM BATHROOM EXISTING TERRACE	1/8" = 1'-0"	EXISTING EXISTING EXISTING EXISTING LIVING ROOM 75CD EXISTING FOYER
ALL DRAWN AND WRITTEN MATERIAL CONTAINED HEREIN IS THE SOLE PROPERTY OF CASTELLANOS DESIGN STUDIO, LLC, AND MAY NOT BE DUPLICATED, PUBLISHED, DISCLOSED OR USED WITHOUT EXPRESS WRITTEN CONSENT OF CASTELLANOS DESIGN STUDIO, LLC, THE DRAWINGS ARE SCOPE DOCUMENTS WHICH INDICATE THE GENERAL SCOPE OF WORK, AND SUCH, DO NOT NECESSARLY DESCRIBE ALL WORK REQUIRED FOR THE PROPER COMPLETION OF ITS WORK WITHOUT ADJUSTMENT TO THE CONTRACT ANOUT UNLESS SCOPE OF WORK CHANGES FROM THAT INDICATED ON THE DRAWINGS. IN THE EVENT OF A CONFLICT WITHIN OR AMONG THE CONTRACT DOCUMENTS, THAT DOCUMENT PLACING THE GENERAL CONTRACTOR SHALL GOVERN THE GENERAL CONTRACTOR SHALL CONTRACTOR SHALL CONFRACTOR SHALL CAREFULLY STUDY AND COMPARE ALL DRAWINGS. REPORTING ANY ERROR, INCONSISTENCY OR OMISSION HE MAY DISCOVER AND REPORT TO CDS AND IN NO CASE SHALL PROCEED IN UNCERTAINTY.	407 LINCOLN ROAD, SUITE 2C MIAMI BEACH, FL 33139 Tel: 786.218.5335 License #AA 26002467 WWW.CASTELLANOSDESIGN.COM No. Date Issued / Revised 1 17 Feb/15 Permitting 12-03-15 RTC 1	CASTELLANOS DESIGN STUDIO

FIRE SCALE:

UNIT #1

EXISTING

PROPERTY LINE

241

77

STREE1

Issued for Permitting

241 77 street Miami Beach, FL 33141

Z